

TYPICAL IRISH WATER DETAIL ON-LINE AIR VALVE

FOR POLYETHYLENE (P.E.) PIPE - NTS

TYPICAL IRISH WATER DETAIL OFF-LINE AIR VALVE FOR POLYETHYLENE (P.E.) PIPE - NTS

FLOOR PLAN

DOUBLE AIR VALVE

(PRECAST CONCRETE CONSTRUCTION)

ROOF PLAN

COVER TO BE SET IN CEMENTITIOUS

(REFER TO NOTE 6.)

DOUBLE AIR VALVE ----


UBLE AIR VALVE

ROOF PLAN

FLOOR PLAN

DOUBLE AIR VALVE

OPE TO BE CLEAN CUT & SEAL

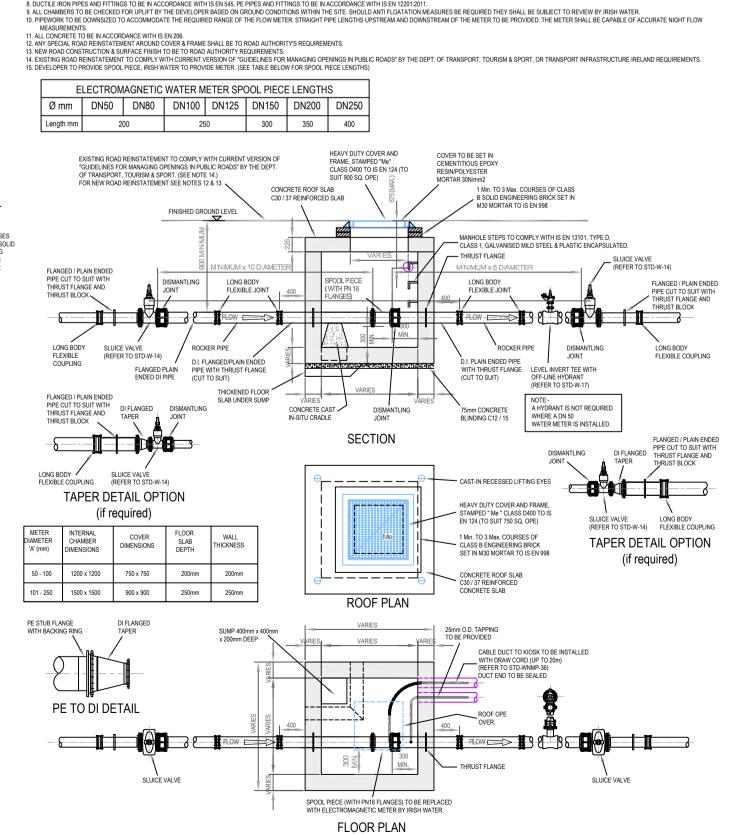

TYPICAL IRISH WATER DETAIL METER CHAMBER -NTS

PLANNING ISSUE

S2.P01 ISSUED FOR PLANNING								08.12.2022		KD	AL
Rev.	Rev. Note								е	Drawn	Check
DO & ASS	NN SOCIATE	ACHAI ES CONSU) LTII	I O'BRIE	RS M	ELM F	T 5C HOUSE IUM PARK LAS LDARE	INFO@DO		PHONE 53 45 984 042 BRIEN-ENGINEERS.IE BRIEN-ENGINEERS.IE	
Client:	Client: WESTAR HOMES LTD										
Project:	FINLAY PARK										
Drawing Title: TYPICAL WATERMAIN DETAILS SHEET 2 OF 3											
Drawn B R	By: LR	Checked By: AL		Approved By: DOB	Date: SEP 2022		Scale: NTS		Sheet A1		
Project Number:			Drawing Number:					St	atus Co	de: Re	/ Number:
DOBA2110			FINLAY-DOB- XX-SI- DR-C-0131						S2	S2 P0	
										'	